

Management Division
Department of Health Service
Ministry of Health & Population




Health Building Infrastructure
Standard Design Drawings


Job Name:-
PRIMARY HOSPITAL CLASS B
TYPE 3
RCC Frame Structure
Two Storied
SCALE:-
DATE :

Drawing Title
Ground Floor Plan
And Front Elevation

Sheet no:
AR/01
01/07

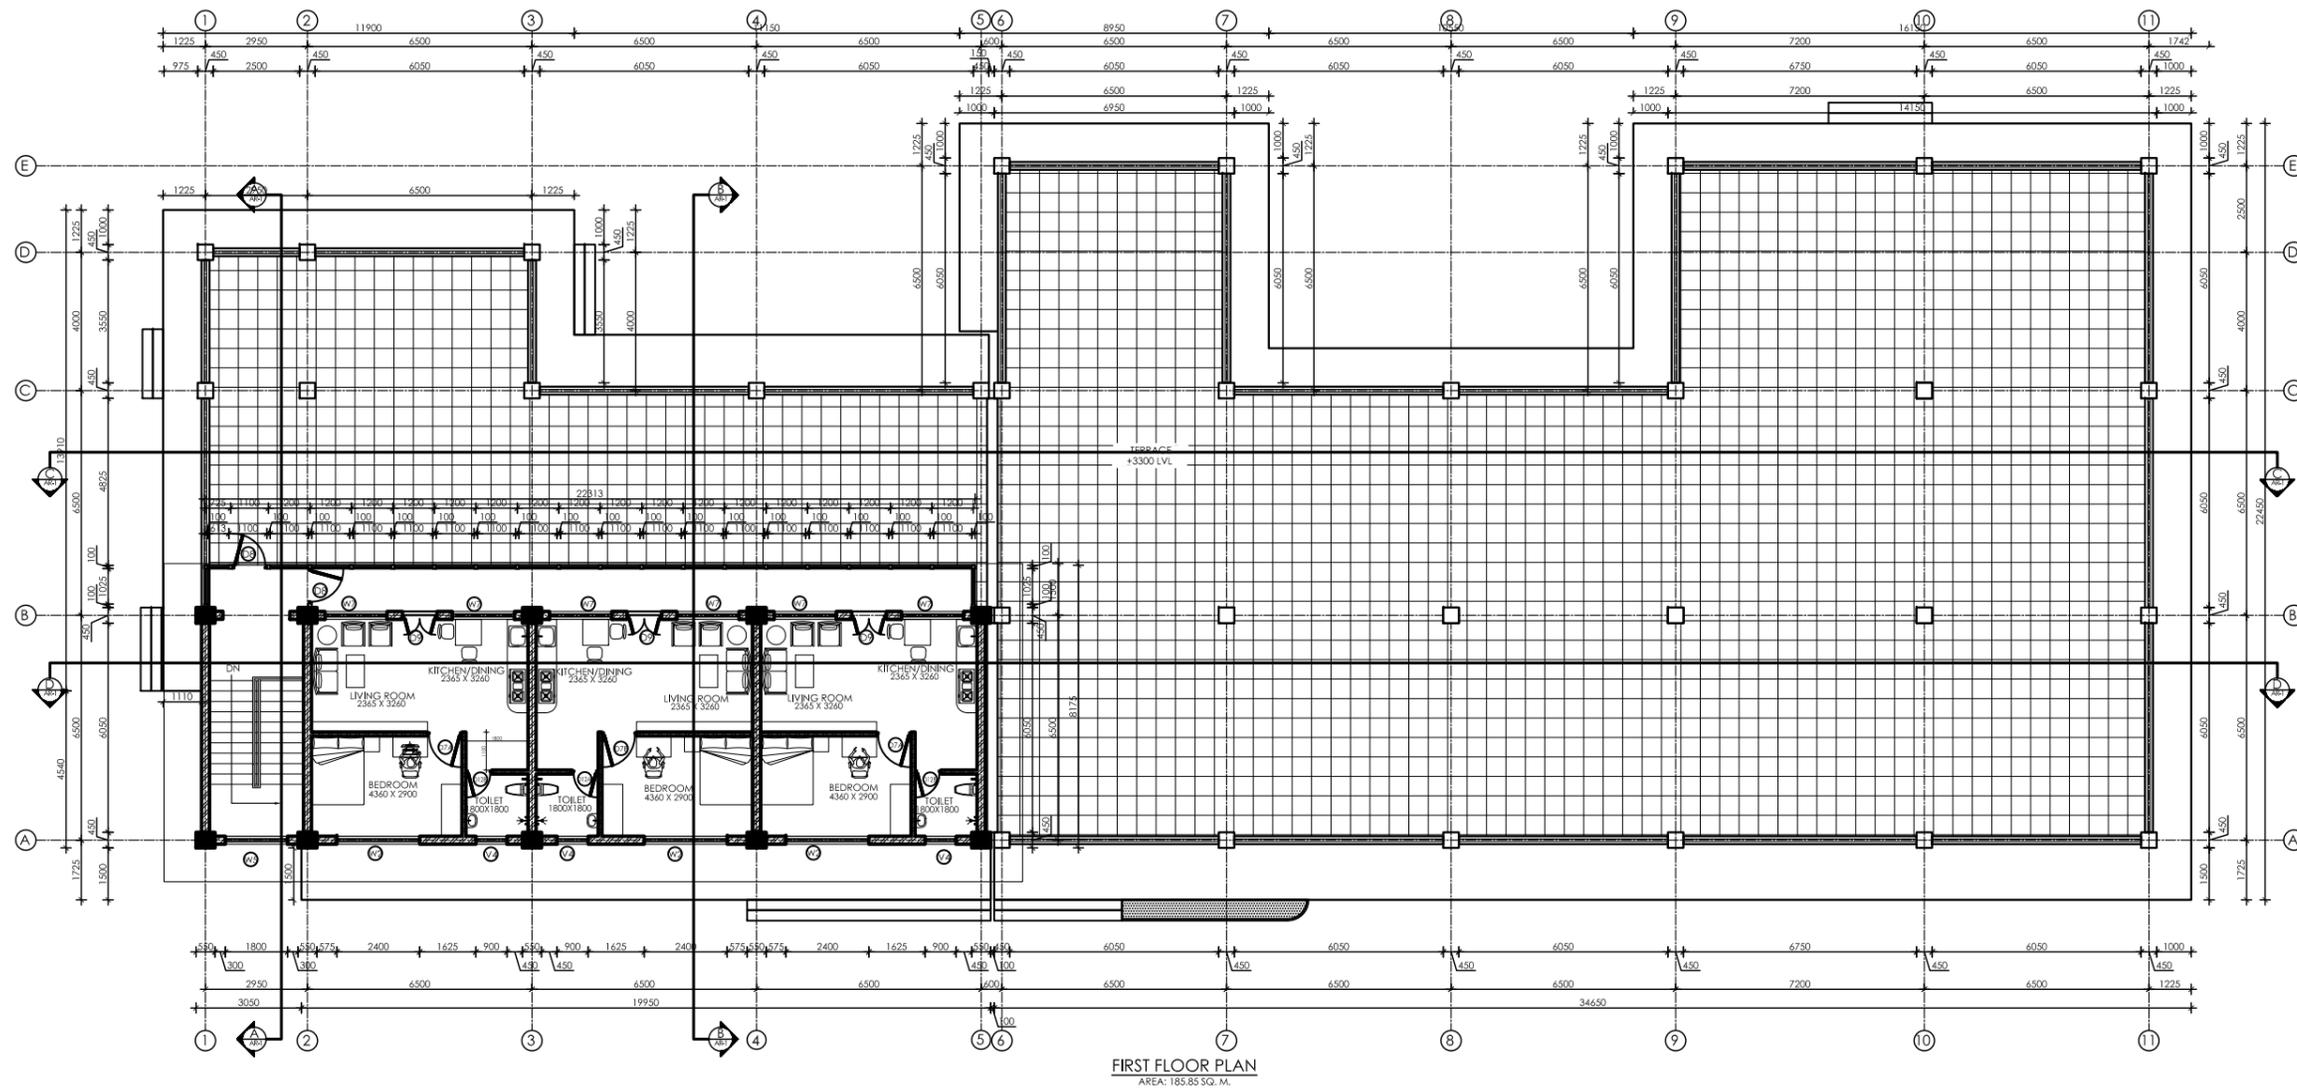

FRONT ELEVATION

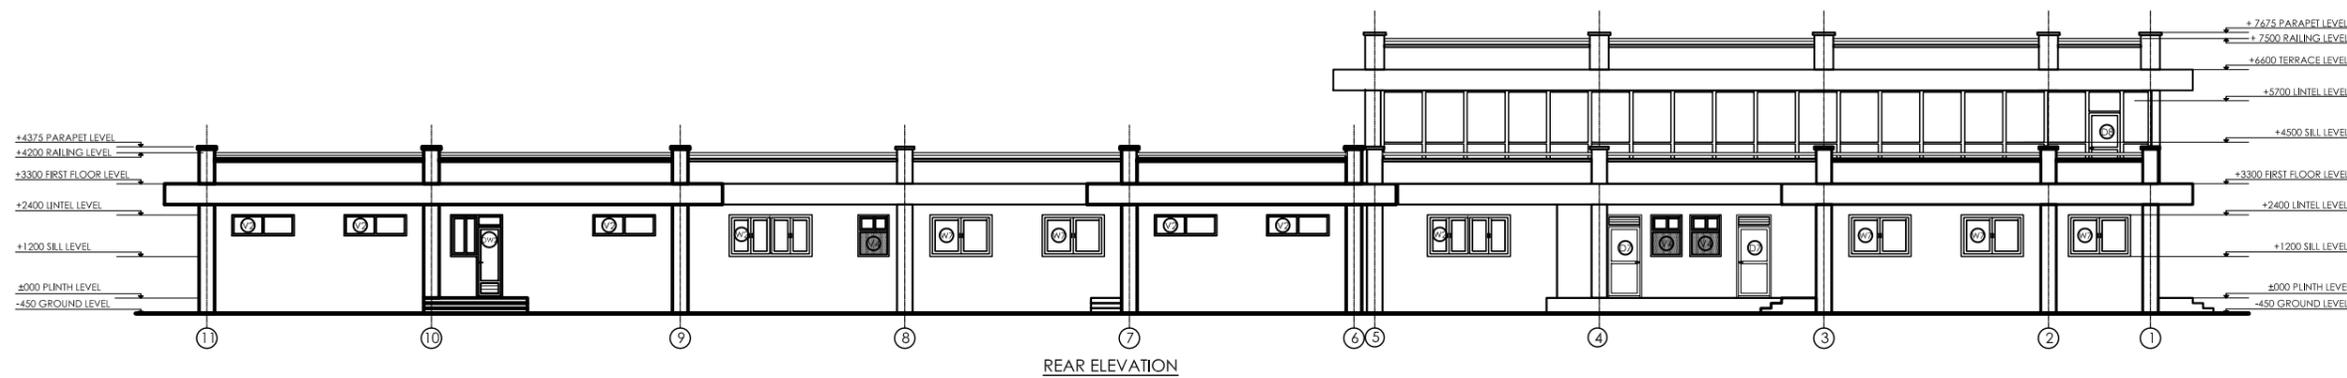

Management Division
Department of Health Service
Ministry of Health & Population



Health Building Infrastructure
Standard Design Drawings

Job Name:-
PRIMARY HOSPITAL CLASS B
TYPE 3
RCC Frame Structure
Two Storied

SCALE:-

DATE :

Drawing Title

Ground Floor Plan
And Front Elevation

Sheet no:

AR/01
01/07